



1033 PORT ROAD WURTLAND, KY 41144 (740) 532-7822



PORTABLESOLUTIONSGROUP.COM

THIS DOCUMENT CONTAINS INFORMATION THAT IS CONFIDENTIAL AND PROPRIETARY TO PORTABLE SOLUTION GROUP, INC (DROPBOX, INC AND MODULA SECURITY SYSTEMS, INC). IT IS PROVIDED WITH THE UNDERSTANDING THAT THIS DOCUMENT AND THE INFORMATION IT CONTAINS WILL NOT BE REPRODUCE OR DISCLOSED WITHOUT THE WRITTEN CONSENT FROM PORTABLE SOLUTIONS GROUP, INC. THIS OTHER THAN CONDUCTING BUSINESS WITH PORTABL SOLUTIONS GROUP, INC. AND/OR ITS ASSOCIATED COMPANIES LISTED ABOVE AND WILL BE RETURNED, AND ALL FURTHER USE DISCONTINUED UPON REQUEST BY PORTABLE SOLUTIONS GROUP, INC.

THIS MSSI PRODUCT IS COVERED BY ONE OR MORE OF THE FOLLOWING PATENTS:

US 9,404,278; US 9,051,748; US 8,671,624; US 8,015,754; US 7,762,025; 7,823,338; CA 2,587,968; CA 2,682,764; EP 1812666; DZ 5173; EG 25627; NG RPNG/C/C2007/737; EP 2137356

CUSTOMER MSSI STANDARDS

MAC1

APPROVED

DRAWING NUMBER M1XX DATE PHOLBROOK 2/21/2023 DATE 3/8/2023 JCALDWELL

NMCCARTY 3/15/2023 **REVISIONS**


DATE

REV	DESCRIPTION	DRAWN	DATE		
0	MANUFACTURI	PDH	2/21/2		
U	NG RELEASE	ן דטח	3		
1	MANUFACTURI	DDH	7/3/23		
	NG RELEASE	PDH	113123		
2	MANUFACTURI	PDH	8/22/2		
	NG RELEASE	PDH	3		

ISOMETRICS ROOF ON

SHEET NUMBER
M1XX-0100

SECURE SIDE NON-SECURE SIDE

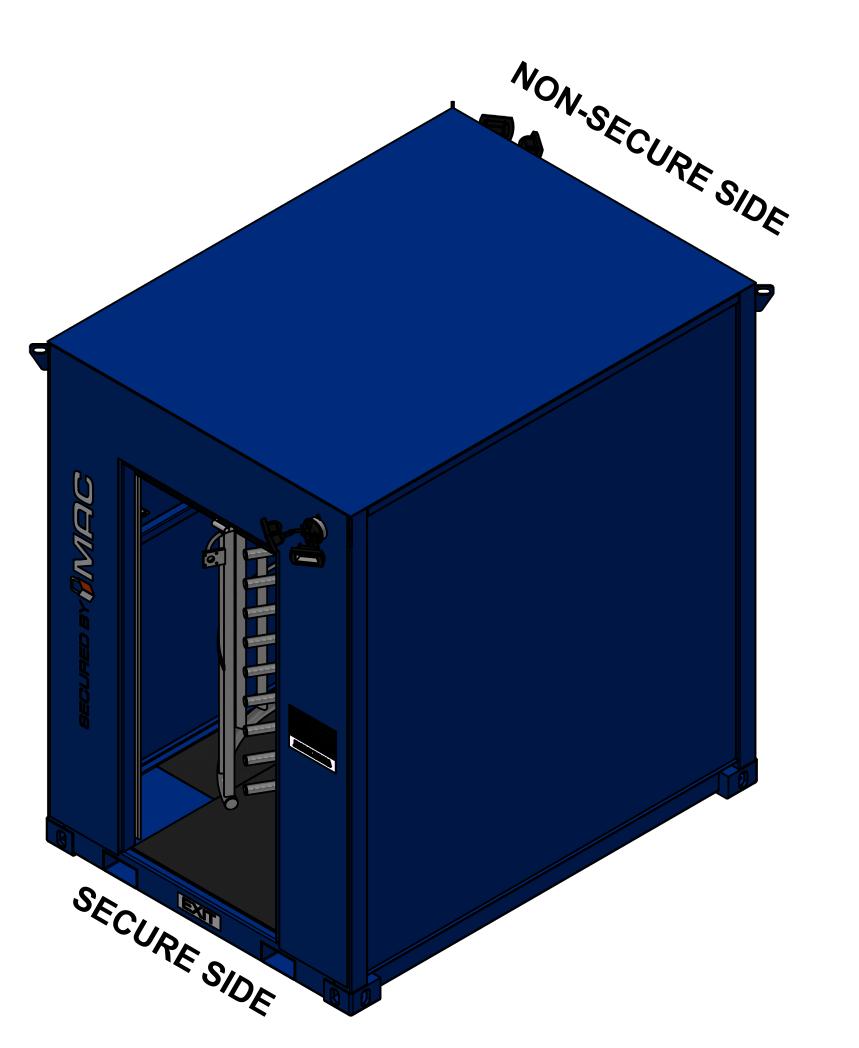





1033 PORT ROAD WURTLAND, KY 41144 (740) 532-7822



PORTABLESOLUTIONSGROUP.COM

THIS DOCUMENT CONTAINS INFORMATION THAT IS CONFIDENTIAL AND PROPRIETARY TO PORTABLE SOLUTION GROUP, INC (DROPBOX, INC AND MODULAR SECURITY SYSTEMS, INC). IT IS PROVIDED WITH THE UNDERSTANDING THAT THIS DOCUMENT AND THE INFORMATION IT CONTAINS WILL NOT BE REPRODUCED OR DISCLOSED WITHOUT THE WRITTEN CONSENT FROM PORTABLE SOLUTIONS GROUP, INC. THIS DOCUMENT WILL NOT BE USED FOR ANY PURPOSE OTHER THAN CONDUCTING BUSINESS WITH PORTABLE SOLUTIONS GROUP, INC. AND/OR ITS ASSOCIATED COMPANIES LISTED ABOVE AND WILL BE RETURNED, AND ALL FURTHER USE DISCONTINUED UPON REQUEST BY PORTABLE SOLUTIONS GROUP, INC.

THIS MSSI PRODUCT IS COVERED BY ONE OR MORE OF THE FOLLOWING PATENTS:

US 9,404,278; US 9,051,748; US 8,671,624; US 8,015,754; US 7,762,025; 7,823,338; CA 2,587,968; CA 2,682,764; EP 1812666; DZ 5173; EG 25627; NG RPNG/C/C2007/737; EP 2137356

CUSTOMER
MSSI STANDARDS

MAC1

DRAWING NUMBER
M1XX

DRAWN
PHOLBROOK

REVIEW DATE

JCALDWELL 3/8/2023

APPROVED DATE

NMCCARTY 3/15/2023

REVISIONS REV DESCRIPTION DRAWN DATE

DATE


2/21/2023

	0	MANUFACTURI	PDH	2/21/2
	U	NG RELEASE	ן דטח	3
	1	MANUFACTURI	PDH	7/3/23
		NG RELEASE	PUH	113123
	2	MANUFACTURI	PDH	8/22/2
		NG RELEASE		3

ISOMETRICS ROOF OFF

SHEET NUMBER
M1XX-0101

SECURE SIDE NON-SECURE SIDE

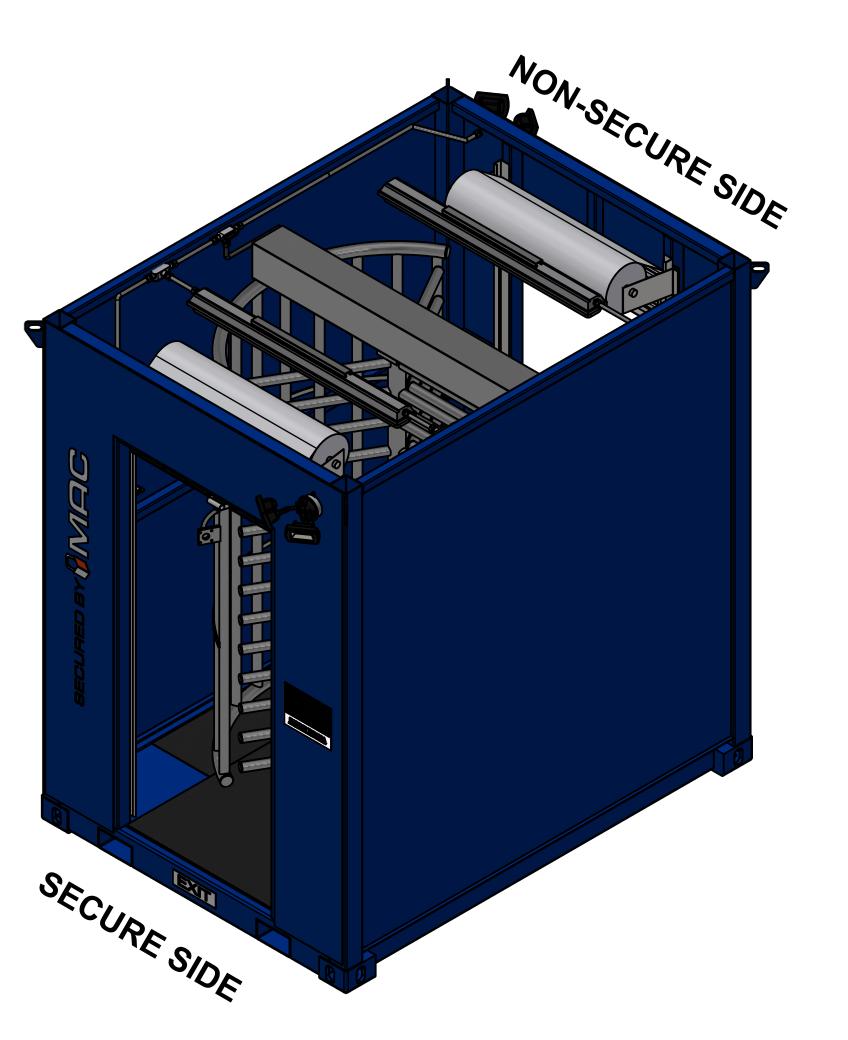

ORIGINAL SHEET SIZE = 22 IN X 34 IN (ANSI D)

В

С

1033 PORT ROAD

WURTLAND, KY 41144 (740) 532-7822



PORTABLESOLUTIONSGROUP.COM

THIS DOCUMENT CONTAINS INFORMATION THAT IS CONFIDENTIAL AND PROPRIETARY TO PORTABLE SOLUTION GROUP, INC (DROPBOX, INC AND MODULA SECURITY SYSTEMS, INC). IT IS PROVIDED WITH THE UNDERSTANDING THAT THIS DOCUMENT AND THE NFORMATION IT CONTAINS WILL NOT BE REPRODUCE OR DISCLOSED WITHOUT THE WRITTEN CONSENT FROM PORTABLE SOLUTIONS GROUP, INC. THIS OTHER THAN CONDUCTING BUSINESS WITH PORTABL SOLUTIONS GROUP, INC. AND/OR ITS ASSOCIATED COMPANIES LISTED ABOVE AND WILL BE RETURNED, AND ALL FURTHER USE DISCONTINUED UPON REQUEST BY PORTABLE SOLUTIONS GROUP, INC.

THIS MSSI PRODUCT IS COVERED BY ONE OR MORE OF THE FOLLOWING PATENTS:

US 9,404,278; US 9,051,748; US 8,671,624; US 8,015,754; US 7,762,025; 7,823,338; CA 2,587,968; CA 2,682,764; EP 1812666; DZ 5173; EG 25627; NG RPNG/C/C2007/737; EP 2137356

CUSTOMER

MSSI STANDARDS

MAC1


DRAWING NUMBER M1XX

DATE 2/21/2023 PHOLBROOK DATE **JCALDWELL** 3/8/2023 APPROVED NMCCARTY 3/15/2023

REVISIONS

REV DESCRIPTION DRAWN DATE MANUFACTURI NG RELEASE MANUFACTURI PDH 7/3/23 NG RELEASE MANUFACTURI 8/22/2 NG RELEASE


> GENERAL ARRANGEMENT **PLAN**

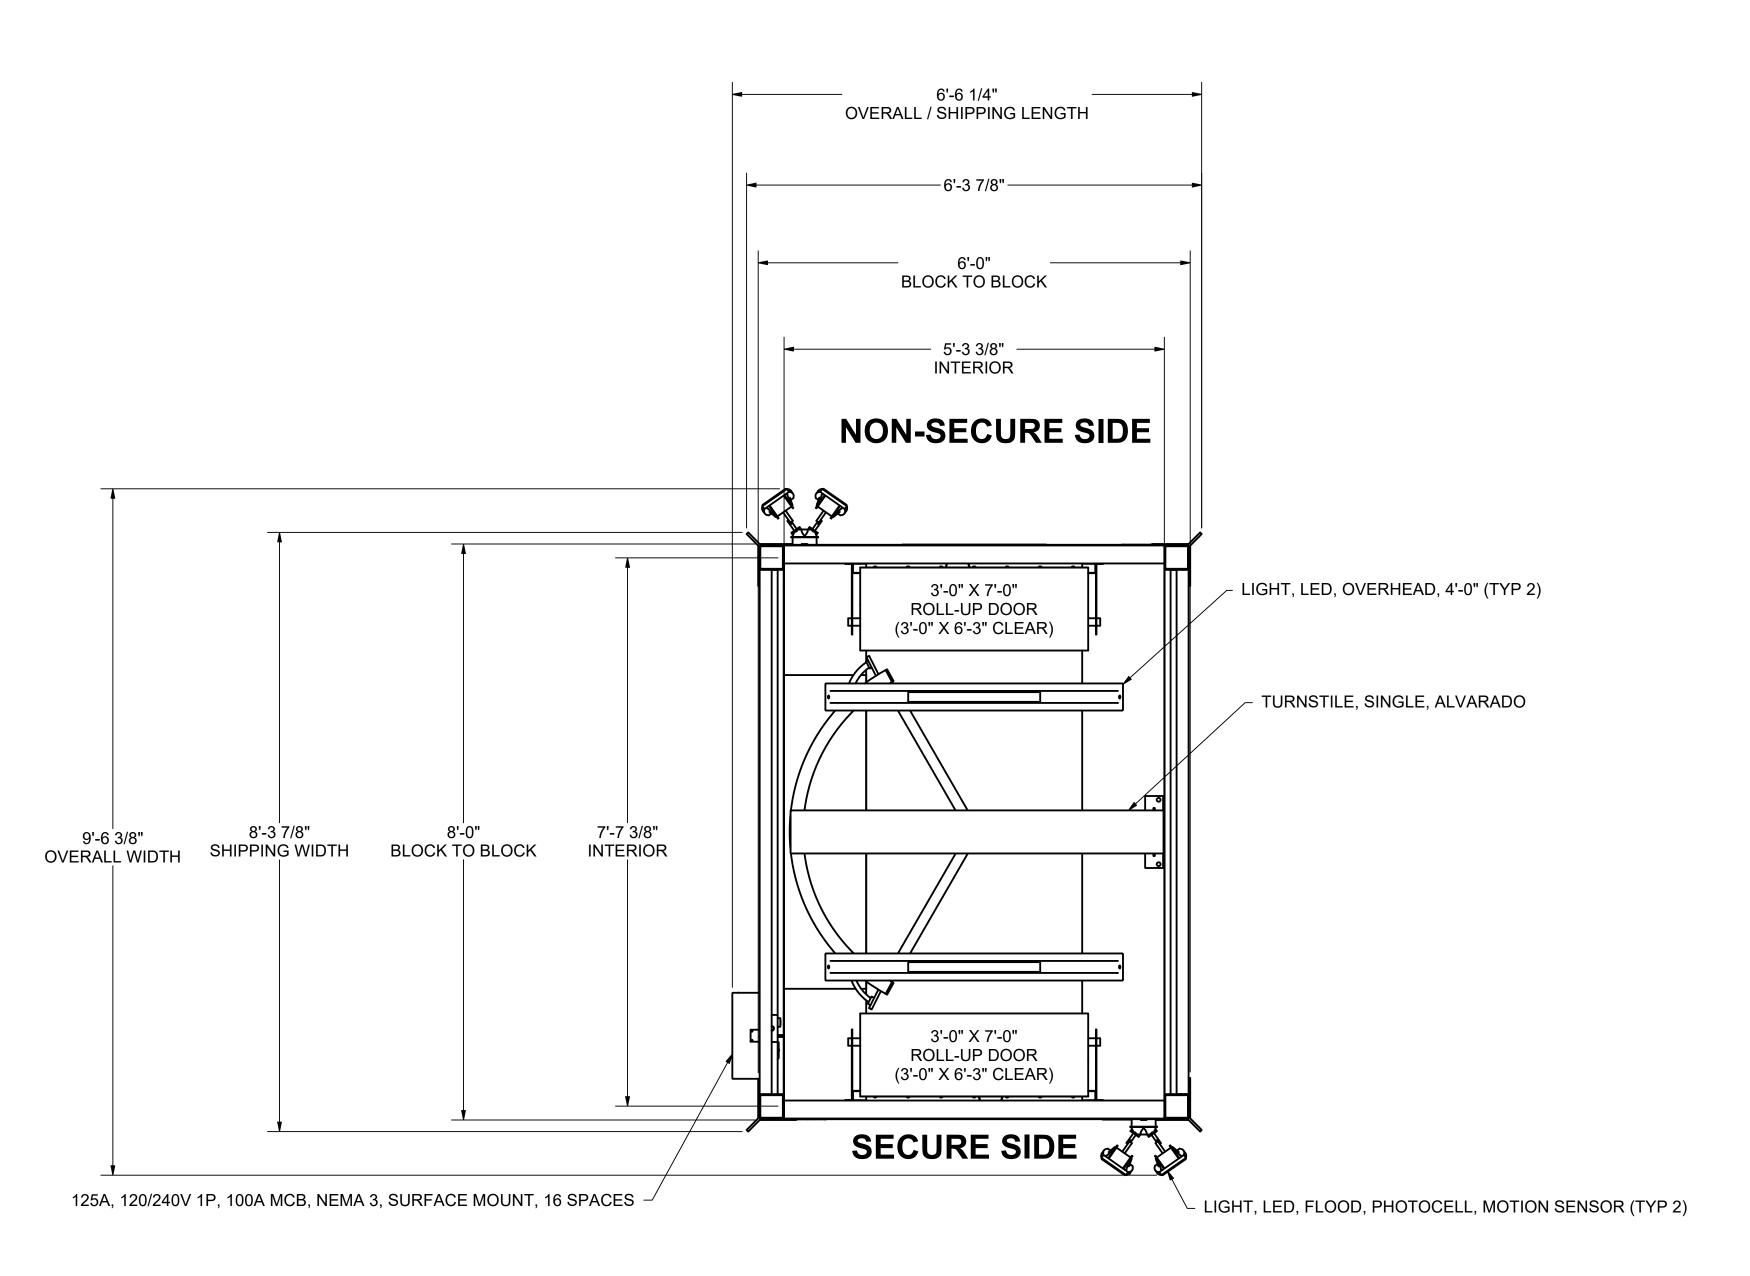


GENERAL ARRANGEMENT PLAN

SCALE: 3/4" = 1'-0"


SHEET NUMBER M1XX-0200

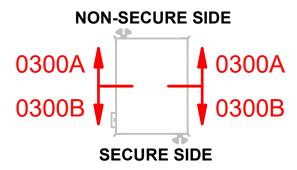

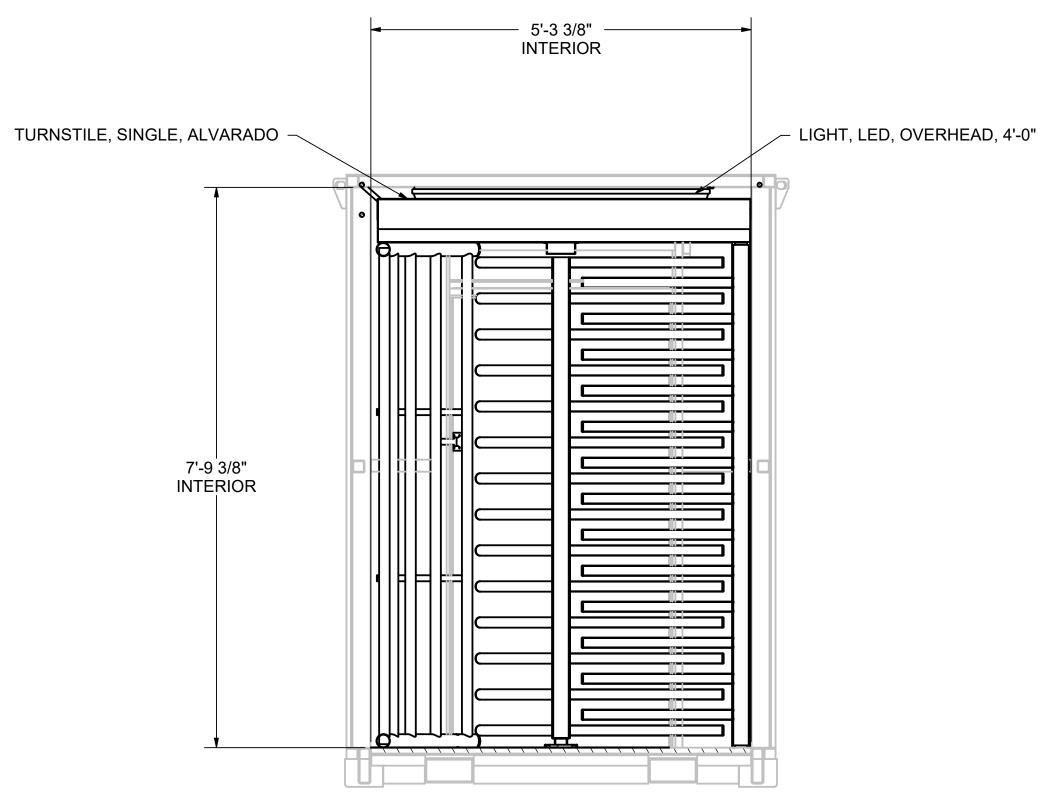

SECTION 0300A

SCALE: 3/4" = 1'-0"

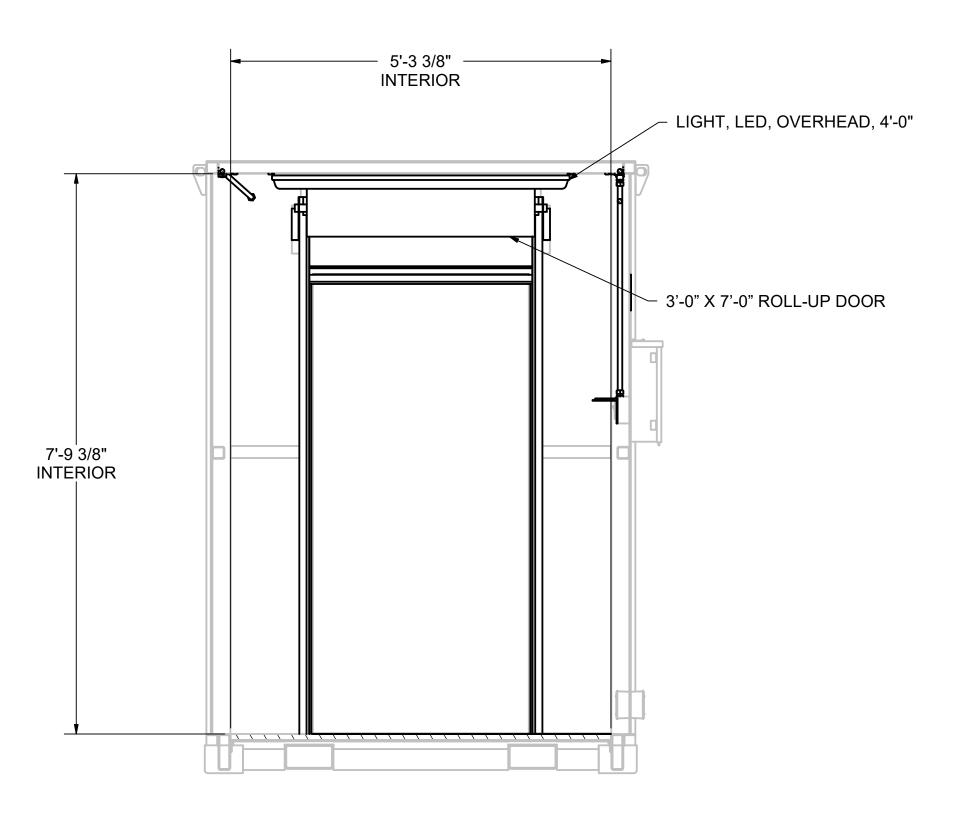

SECTION 0300B (TURNSTILE NOT SHOWN FOR CLARITY) SCALE: 3/4" = 1'-0"



1033 PORT ROAD WURTLAND, KY 41144 (740) 532-7822



PORTABLESOLUTIONSGROUP.COM

THIS DOCUMENT CONTAINS INFORMATION THAT IS CONFIDENTIAL AND PROPRIETARY TO PORTABLE SOLUTION GROUP, INC (DROPBOX, INC AND MODULA SECURITY SYSTEMS, INC). IT IS PROVIDED WITH THE UNDERSTANDING THAT THIS DOCUMENT AND THE INFORMATION IT CONTAINS WILL NOT BE REPRODUCE OR DISCLOSED WITHOUT THE WRITTEN CONSENT FROM PORTABLE SOLUTIONS GROUP, INC. THIS DOCUMENT WILL NOT BE USED FOR ANY PURPOSE OTHER THAN CONDUCTING BUSINESS WITH PORTABL SOLUTIONS GROUP, INC. AND/OR ITS ASSOCIATED COMPANIES LISTED ABOVE AND WILL BE RETURNED, AND ALL FURTHER USE DISCONTINUED UPON REQUEST BY PORTABLE SOLUTIONS GROUP, INC.

THIS MSSI PRODUCT IS COVERED BY ONE OR MORE OF THE FOLLOWING PATENTS:

US 9,404,278; US 9,051,748; US 8,671,624; US 8,015,754; US 7,762,025; 7,823,338; CA 2,587,968; CA 2,682,764; EP 1812666; DZ 5173; EG 25627; NG RPNG/C/C2007/737; EP 2137356

CUSTOMER MSSI STANDARDS

MAC1

DRAWING NUMBER M1XX


DRAWN	DATE
PHOLBROOK	2/21/2023
REVIEW	DATE
JCALDWELL	3/8/2023
APPROVED	DATE
NMCCARTY	3/15/2023

REVISIONS

REV	DESCRIPTION	DRAWN	DATE
0	MANUFACTURI	PDH	2/21/2
	NG RELEASE	PDH	3
1	MANUFACTURI	PDH	7/3/23
	NG RELEASE	ן פטח	
2	MANUFACTURI	PDH	8/22/2
	NG RELEASE	ן פטח	3

INTERIOR SECTIONS 0300A - B

SHEET NUMBER M1XX-0300

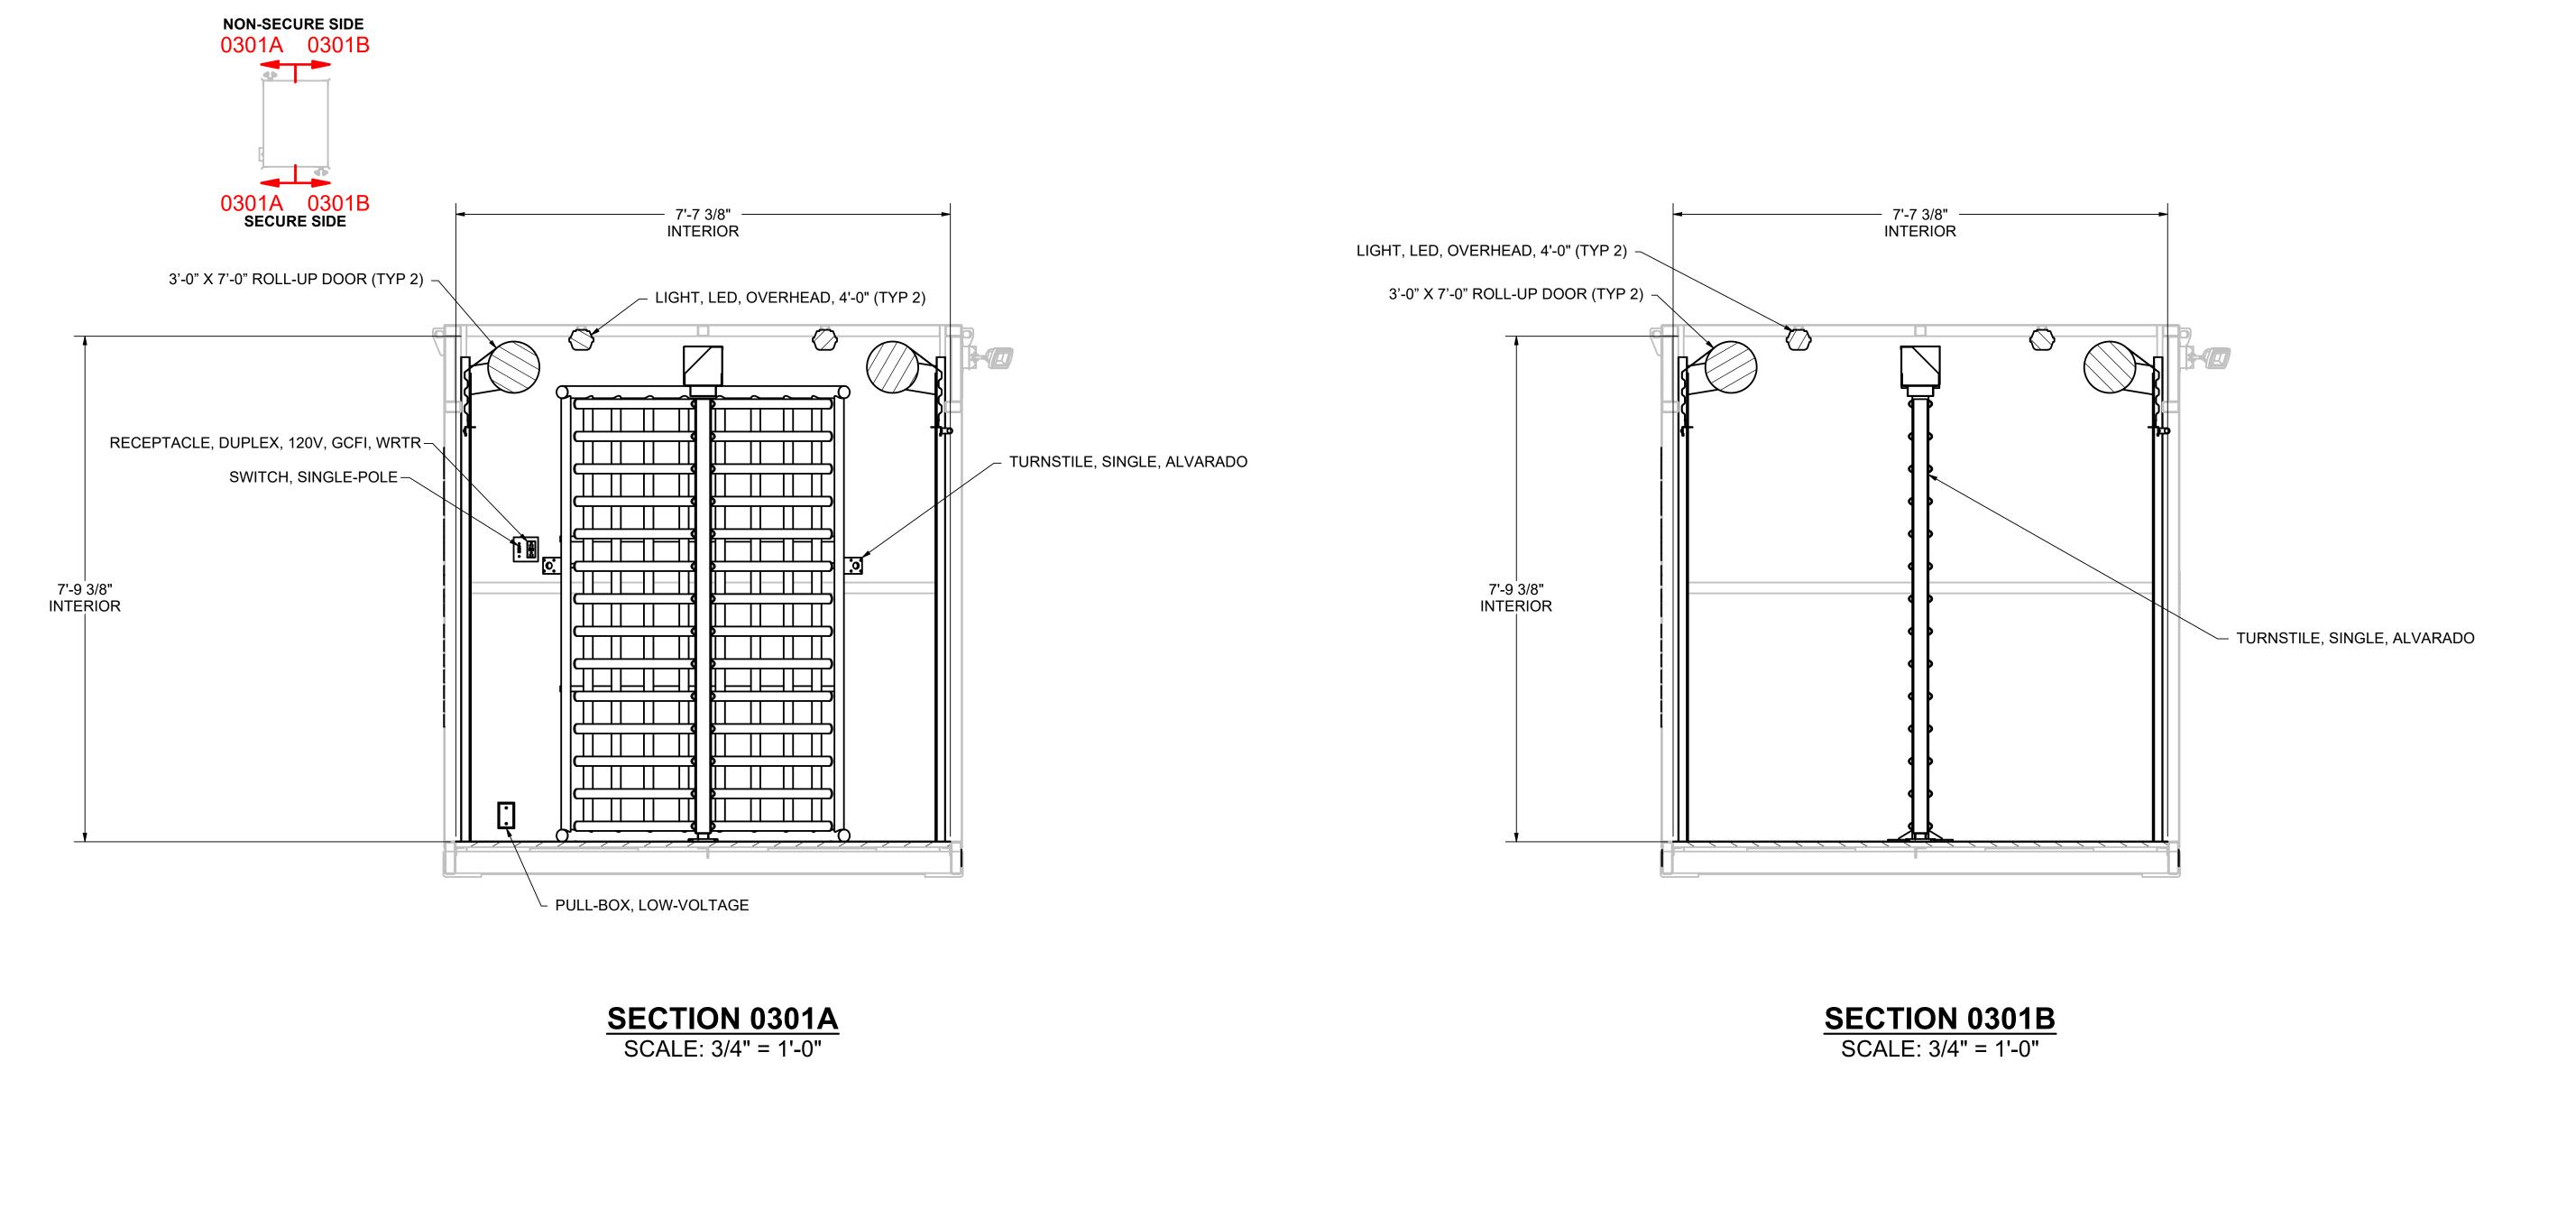

PORTABLE SOLUTIONS GROU

1033 PORT ROAD WURTLAND, KY 41144 (740) 532-7822



PORTABLESOLUTIONSGROUP.COM

THIS DOCUMENT CONTAINS INFORMATION THAT IS CONFIDENTIAL AND PROPRIETARY TO PORTABLE SOLUTION GROUP, INC (DROPBOX, INC AND MODULAR SECURITY SYSTEMS, INC). IT IS PROVIDED WITH THE UNDERSTANDING THAT THIS DOCUMENT AND THE INFORMATION IT CONTAINS WILL NOT BE REPRODUCED OR DISCLOSED WITHOUT THE WRITTEN CONSENT FROM PORTABLE SOLUTIONS GROUP, INC. THIS DOCUMENT WILL NOT BE USED FOR ANY PURPOSE OTHER THAN CONDUCTING BUSINESS WITH PORTABLE SOLUTIONS GROUP, INC. AND/OR ITS ASSOCIATED COMPANIES LISTED ABOVE AND WILL BE RETURNED, AND ALL FURTHER USE DISCONTINUED UPON REQUEST BY PORTABLE SOLUTIONS GROUP, INC.

THIS MSSI PRODUCT IS COVERED BY ONE OR MORE OF THE FOLLOWING PATENTS:

US 9,404,278; US 9,051,748; US 8,671,624; US 8,015,754; US 7,762,025; 7,823,338; CA 2,587,968; CA 2,682,764; EP 1812666; DZ 5173; EG 25627; NG RPNG/C/C2007/737; EP 2137356

CUSTOMER
MSSI STANDARDS

DRAWING NUMBER
M1XX

DRAWN
PHOLBROOK

REVIEW DATE

JCALDWELL 3/8/2023

APPROVED DATE

NMCCARTY 3/15/2023

REVISIONS
REV DESCRIPTION DRAWN DATE

DATE


2/21/2023


0 MANUFACTURI NG RELEASE
1 MANUFACTURI NG RELEASE
2 MANUFACTURI NG RELEASE
2 MANUFACTURI NG RELEASE
3 PDH 7/3/23 PDH 8/22/2 3


INTERIOR SECTIONS 0301A - B

SHEET NUMBER
M1XX-0301


C

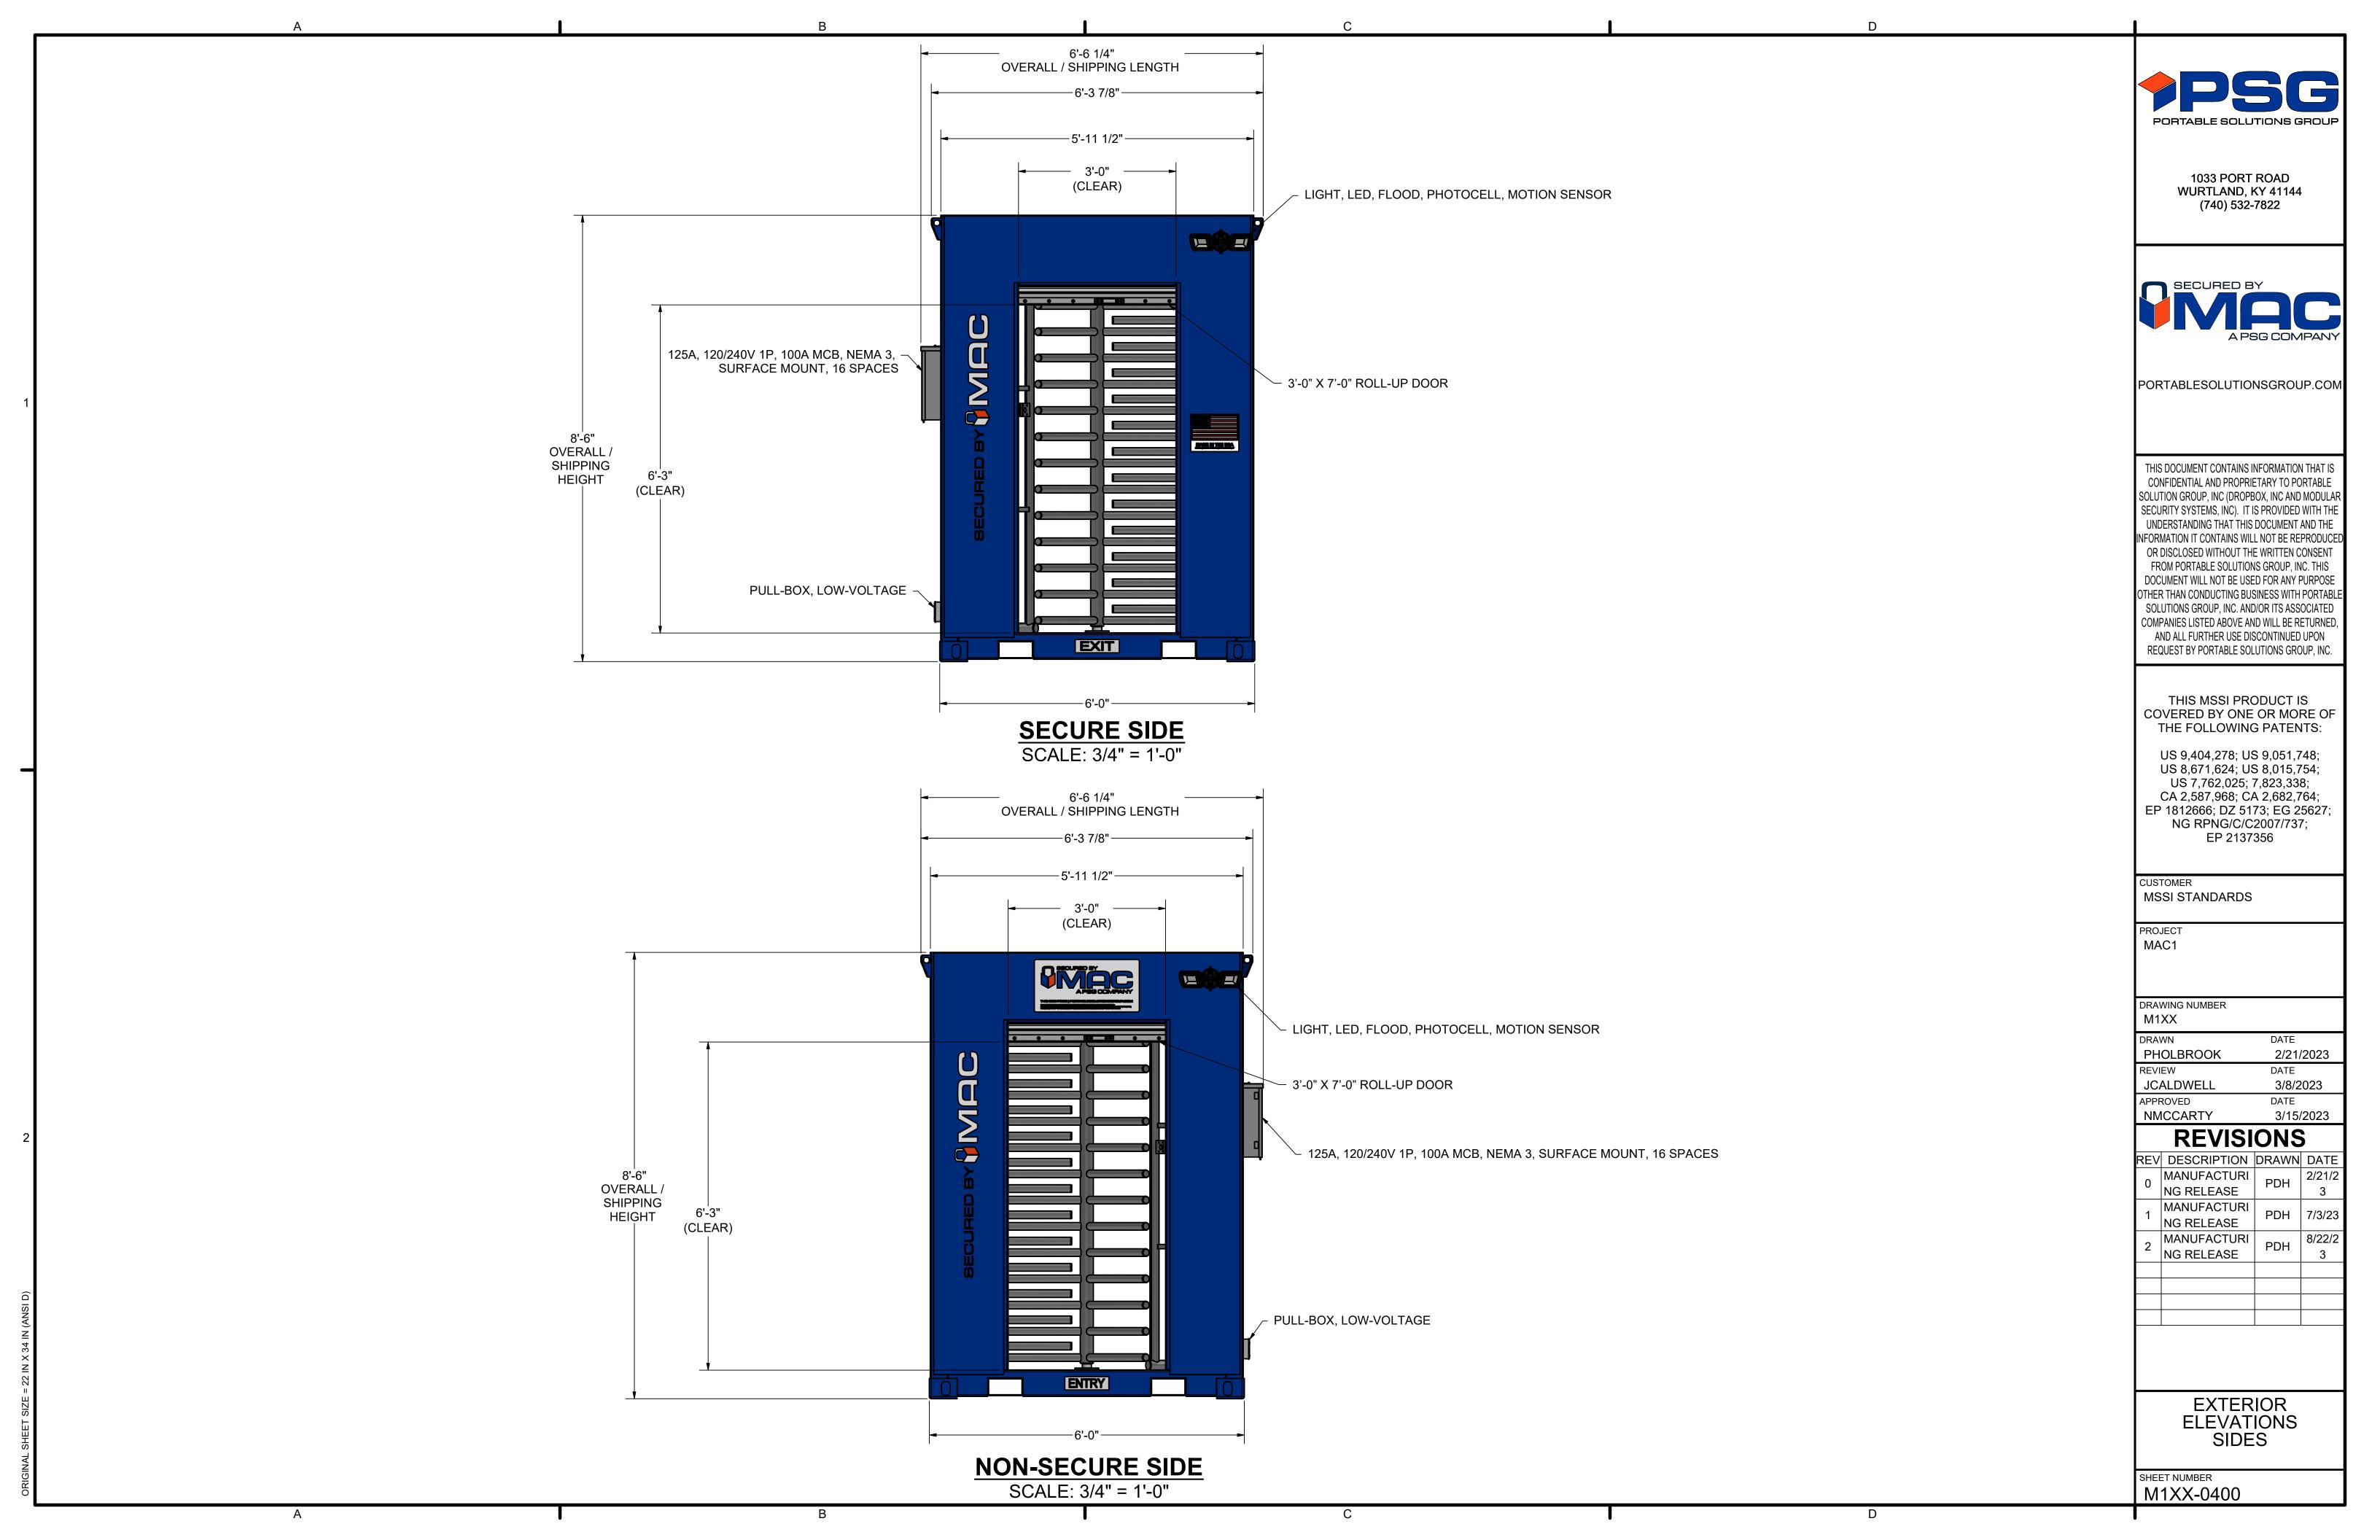

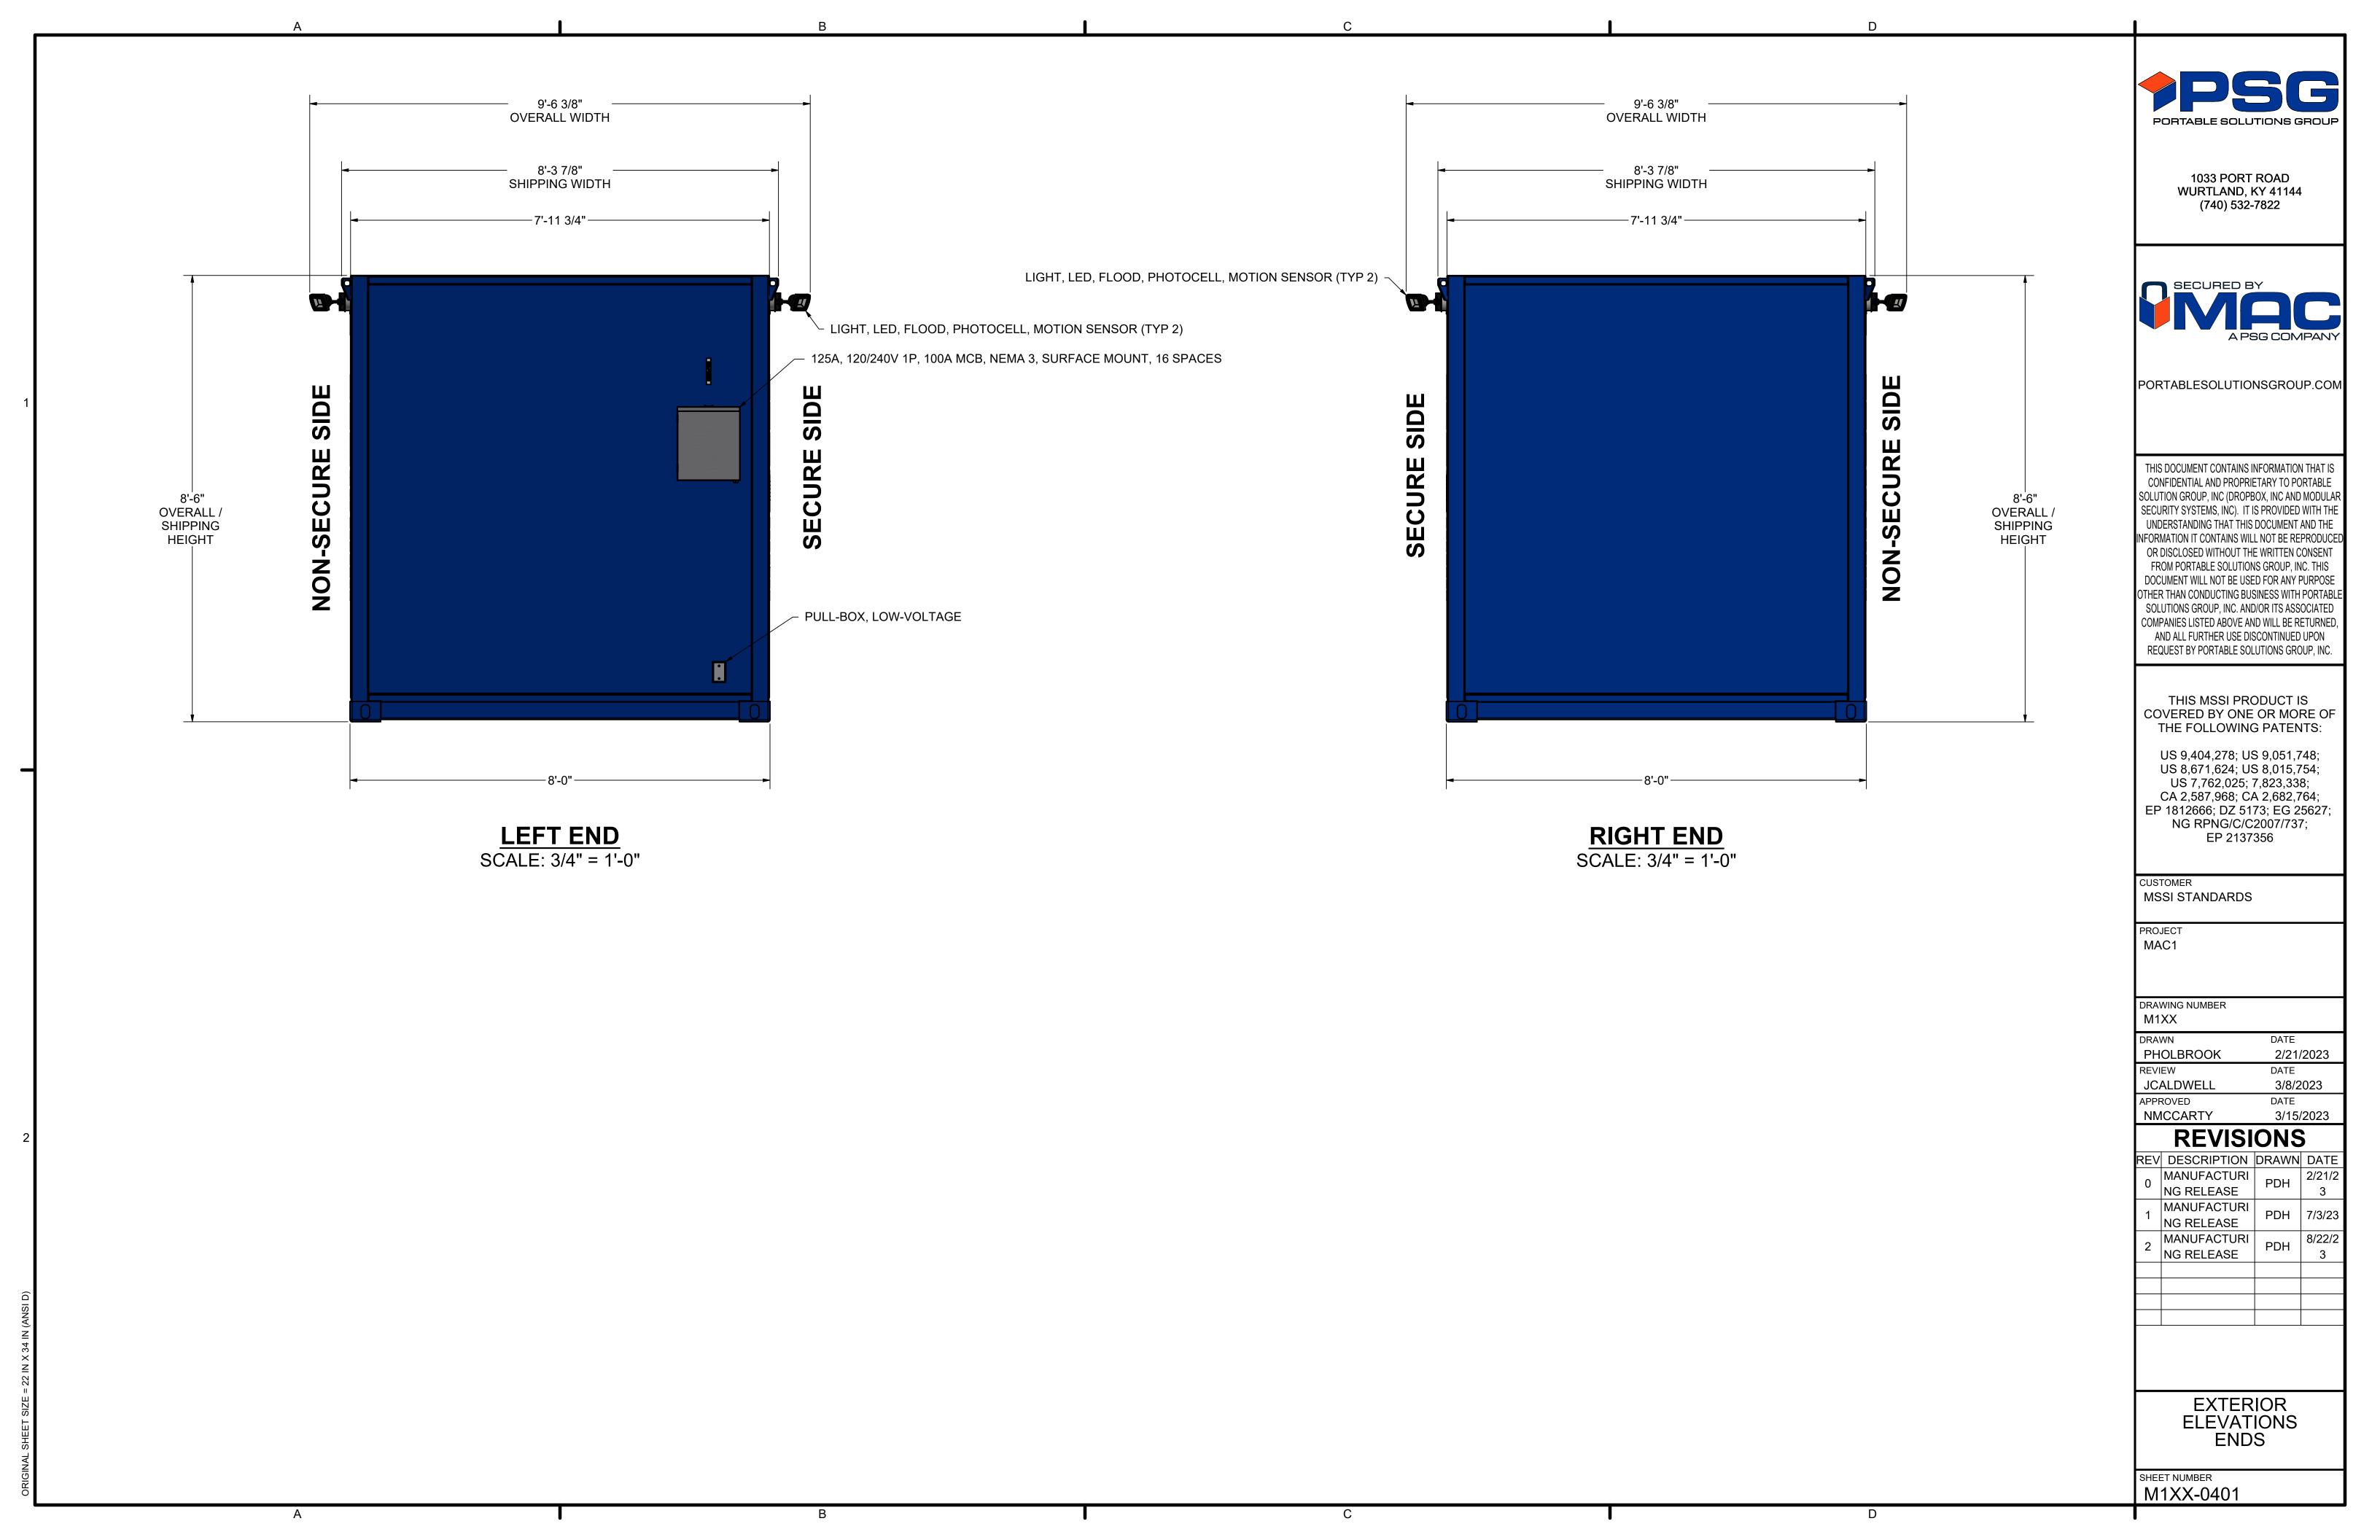

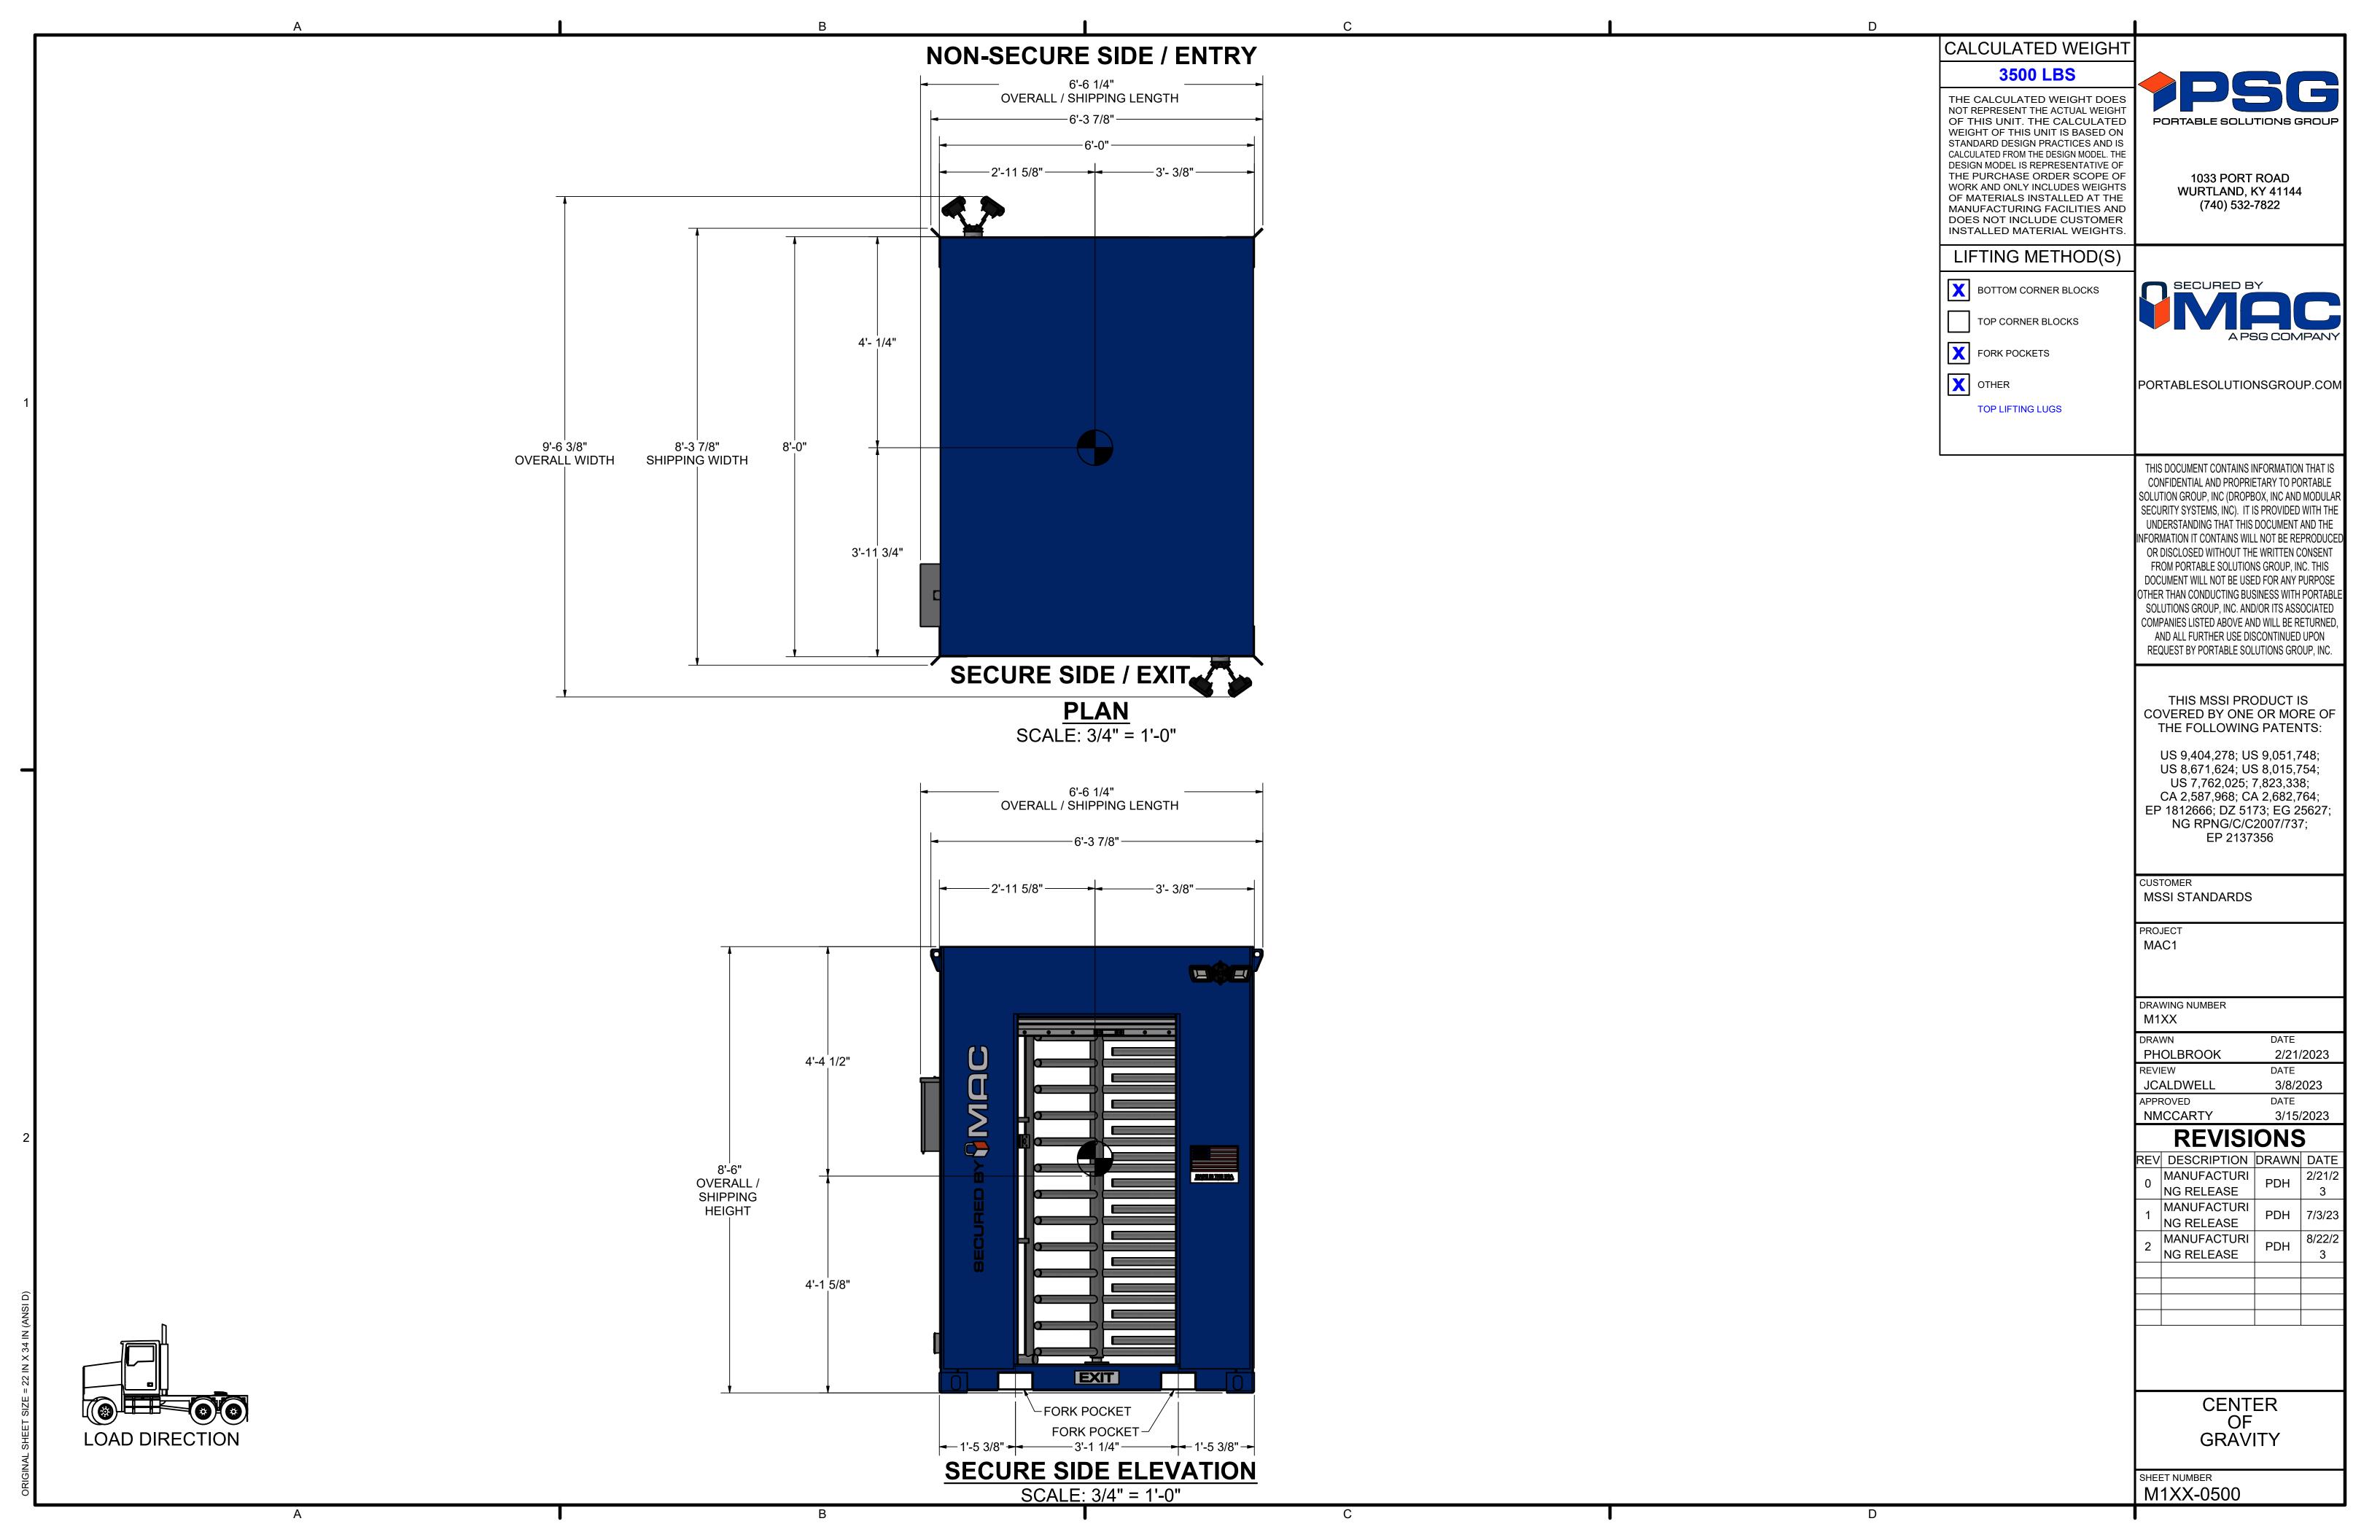

A	В	C		D	
		ELECTRICAL NOTES		ELECTRICAL SYMBOLS	
		ALL EXTERIOR FITTINGS NEED TO BE GASKETED.	<u> </u>	400) / DUDLE) / DECEDTA OLE	→PSG
		2. ALL EXTERIOR ELECTRICAL BOXES NEED TO BE SEALED WITH SILICONE.	\bigcirc	120V DUPLEX RECEPTACLE	PORTABLE SOLUTIONS GROUP
		3. ALL EXTERIOR ELECTRICAL BOXES CAN BE ADJUSTED TO MOUNT ON NEAREST HIGH RIB UNLESS SPECIFIED.		120V QUAD RECEPTACLE	1033 PORT ROAD WURTLAND, KY 41144
			GFCI	120V DUPLEX RECEPTACLE, GROUND-FAULT CIRCUIT-INTERRUPTER (GFCI)	(740) 532-7822
			GFCI	120V QUAD RECEPTACLE, GROUND-FAULT CIRCUIT-INTERRUPTER (GFCI)	SECURED BY
				120V DUPLEX RECEPTACLE, WEATHER-RESISTANT TAMPER-RESISTANT (WRTR)	A PSG COMPANY
1			\ominus	SINGLE RECEPTACLE	PORTABLESOLUTIONSGROUP.COM
			AMPS TYPE		THIS DOCUMENT CONTAINS INFORMATION THAT IS CONFIDENTIAL AND PROPRIETARY TO PORTABLE SOLUTION GROUP, INC (DROPBOX, INC AND MODULAR SECURITY SYSTEMS, INC.) IT IS PROVIDED WITH THE
			\$	CINICI E DOLE CIMITOLI	SECURITY SYSTEMS, INC). IT IS PROVIDED WITH THE UNDERSTANDING THAT THIS DOCUMENT AND THE INFORMATION IT CONTAINS WILL NOT BE REPRODUCED OR DISCLOSED WITHOUT THE WRITTEN CONSENT FROM PORTABLE SOLUTIONS GROUP, INC. THIS
			\$ ₃	THREE-WAY SWITCH	DOCUMENT WILL NOT BE USED FOR ANY PURPOSE OTHER THAN CONDUCTING BUSINESS WITH PORTABLE SOLUTIONS GROUP, INC. AND/OR ITS ASSOCIATED COMPANIES LISTED ABOVE AND WILL BE RETURNED,
			\$ _{occ}	SINGLE-POLE SWITCH, OCCUPANCY SENSOR	AND ALL FURTHER USE DISCONTINUED UPON REQUEST BY PORTABLE SOLUTIONS GROUP, INC.
			\$ 3 occ	THREE-WAY SWITCH, OCCUPANCY SENSOR	THIS MSSI PRODUCT IS COVERED BY ONE OR MORE OF THE FOLLOWING PATENTS: US 9,404,278; US 9,051,748;
			<u>J</u>	JUNCTION BOX	US 8,671,624; US 8,015,754; US 7,762,025; 7,823,338; CA 2,587,968; CA 2,682,764; EP 1812666; DZ 5173; EG 25627; NG RPNG/C/C2007/737;
				DATA	EP 2137356
			FL	FLOOD LIGHT	CUSTOMER MSSI STANDARDS
				LUMEN SETTINGS	PROJECT MAC1
			TURNSTIL		
				Y DEFAULT IS HIGHEST SETTING. SWITCH TO VALUES STATED ABOVE	DRAWING NUMBER M1XX
			FOR EACH ARE		DRAWN DATE PHOLBROOK 2/21/2023
					JCALDWELL 3/8/2023
					APPROVED DATE NMCCARTY 3/15/2023
					REVISIONS REV DESCRIPTION DRAWN DATE
					0 MANUFACTURI PDH 2/21/2 3
					1 MANUFACTURI PDH 7/3/23
					2 MANUFACTURI PDH 8/22/2 3
$\widehat{\mathbf{G}}$					
(ANS)					
× γ γ γ γ γ γ γ γ γ γ γ γ γ γ γ γ γ γ γ					
E = 25 II					
L SHEET SIZ					ELECTRICAL NOTES 1 OF 1
ORIGINA					SHEET NUMBER M1XX-E000
A	В	C		D	IVI I/\/\=LUUU

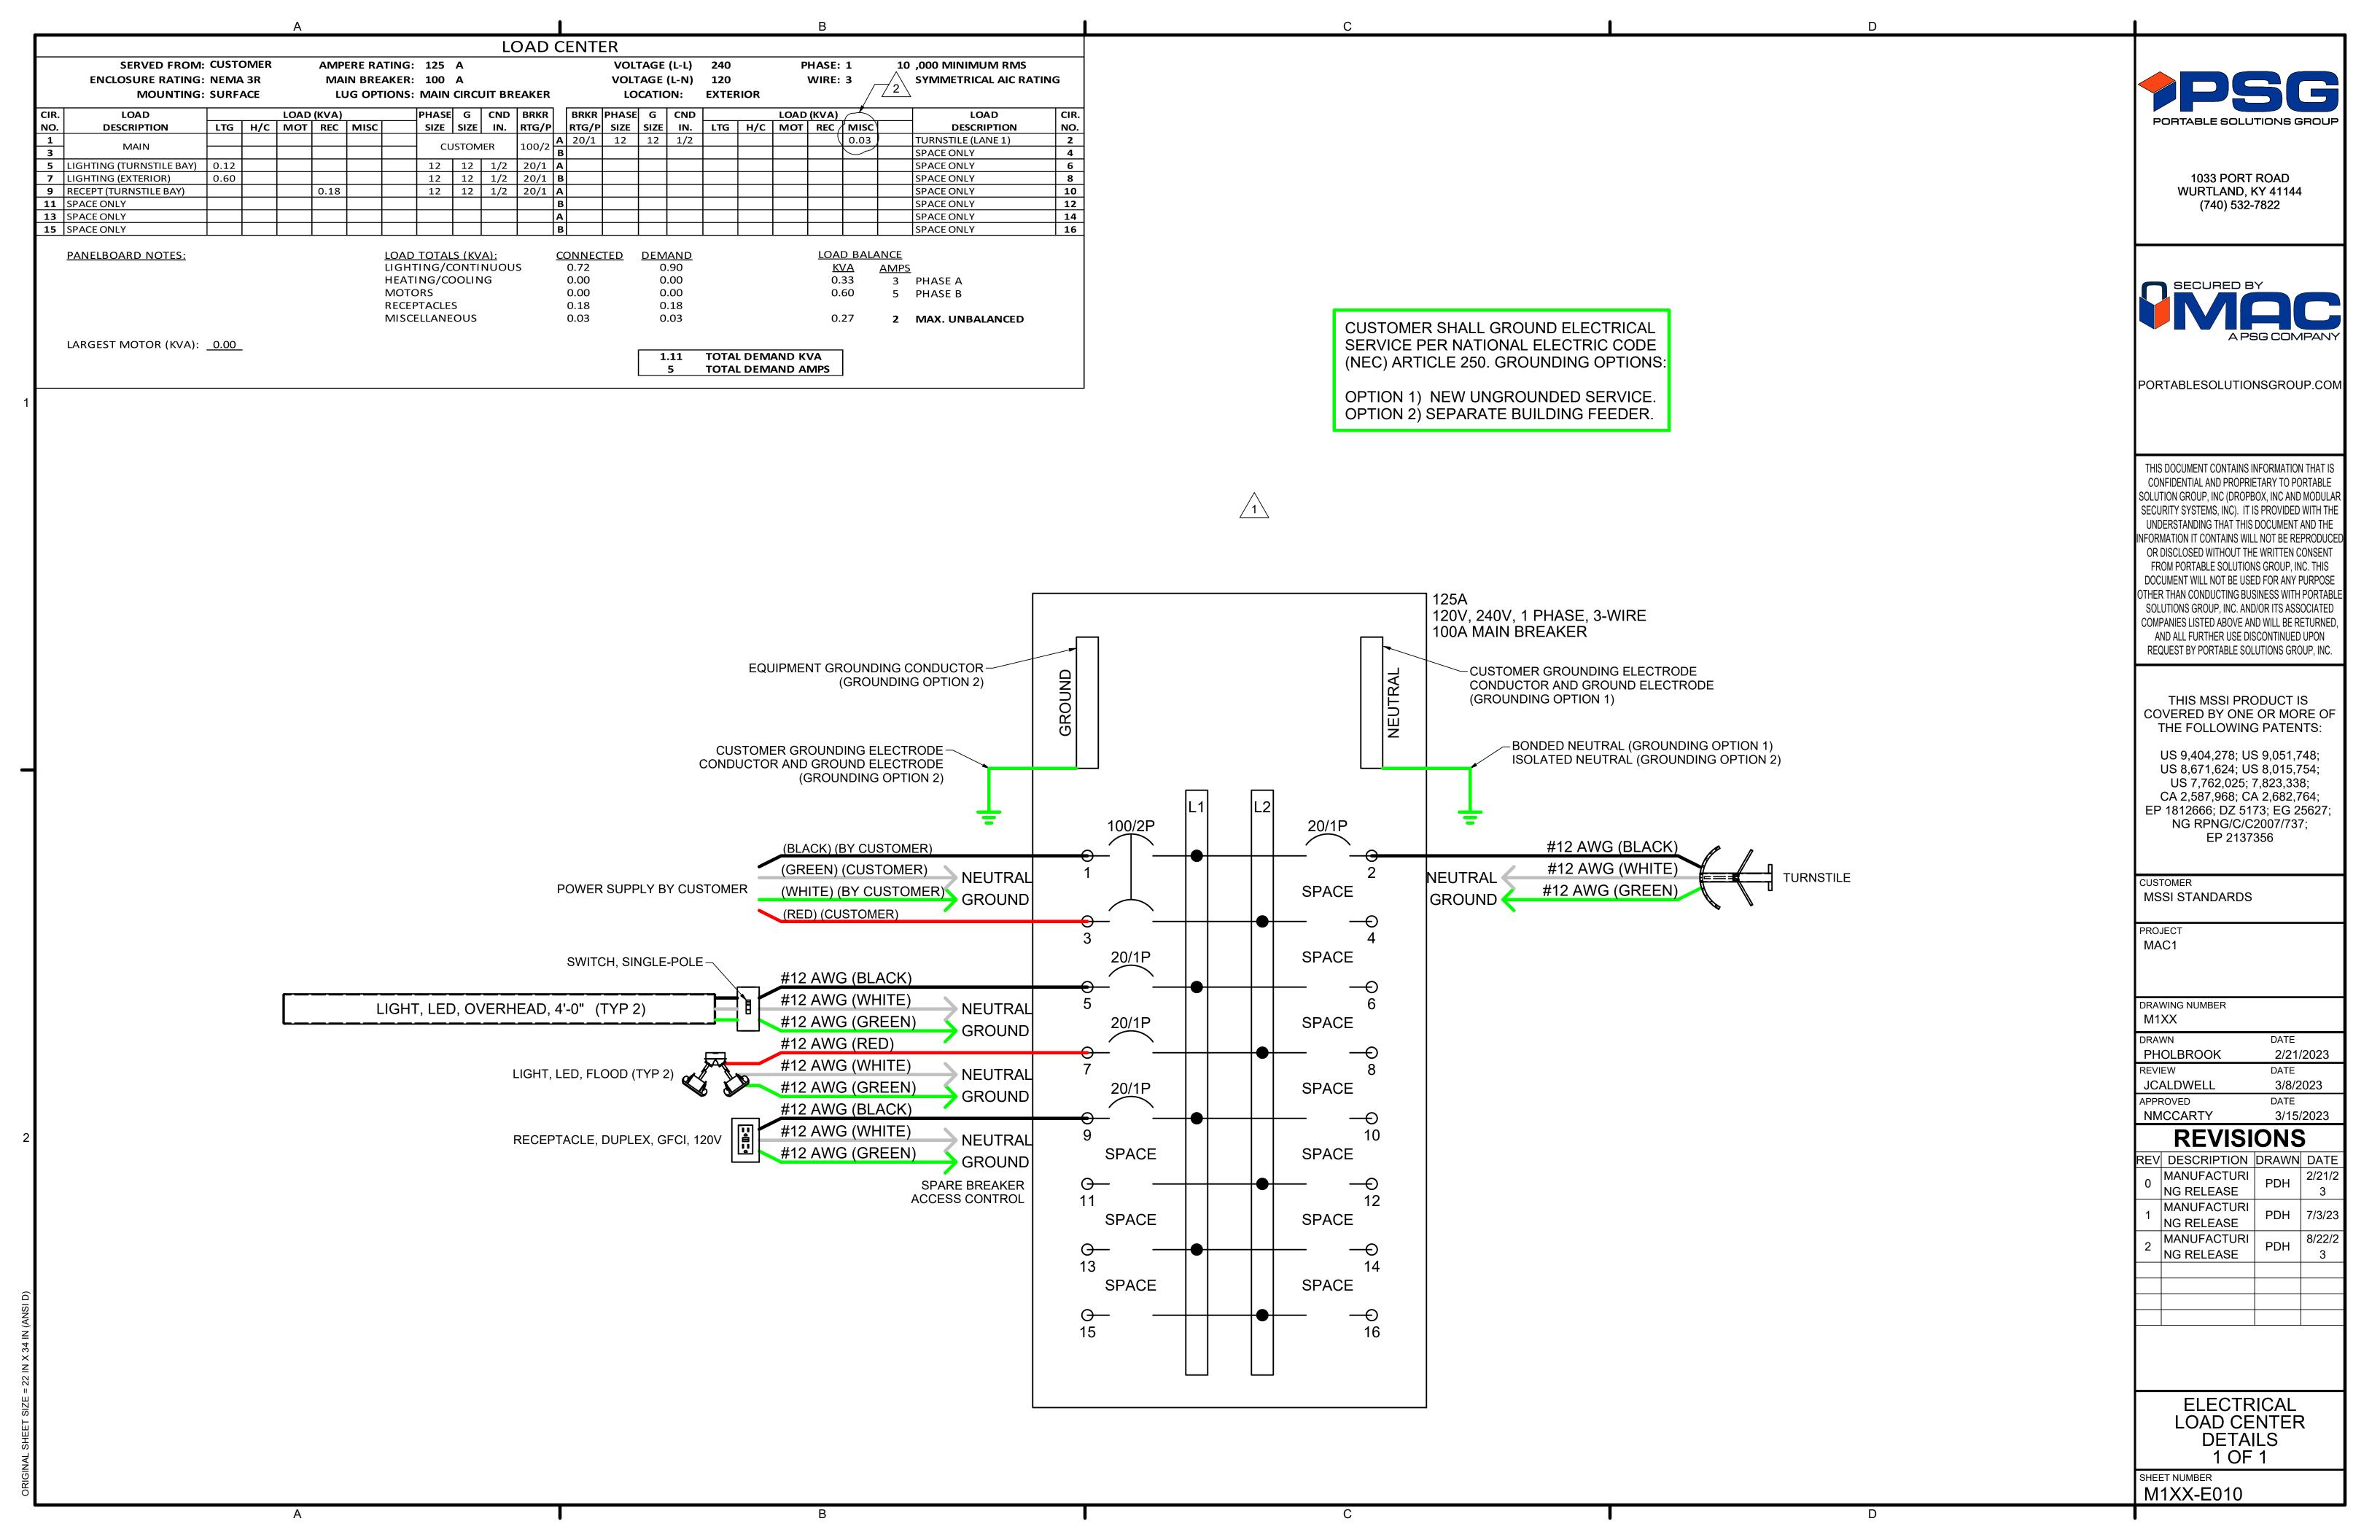

1033 PORT ROAD WURTLAND, KY 41144 (740) 532-7822



PORTABLESOLUTIONSGROUP.COM

THIS DOCUMENT CONTAINS INFORMATION THAT IS CONFIDENTIAL AND PROPRIETARY TO PORTABLE SOLUTION GROUP, INC (DROPBOX, INC AND MODULA SECURITY SYSTEMS, INC). IT IS PROVIDED WITH THE UNDERSTANDING THAT THIS DOCUMENT AND THE NFORMATION IT CONTAINS WILL NOT BE REPRODUCE OR DISCLOSED WITHOUT THE WRITTEN CONSENT FROM PORTABLE SOLUTIONS GROUP, INC. THIS DOCUMENT WILL NOT BE USED FOR ANY PURPOSE OTHER THAN CONDUCTING BUSINESS WITH PORTABL SOLUTIONS GROUP, INC. AND/OR ITS ASSOCIATED COMPANIES LISTED ABOVE AND WILL BE RETURNED, AND ALL FURTHER USE DISCONTINUED UPON REQUEST BY PORTABLE SOLUTIONS GROUP, INC.

THIS MSSI PRODUCT IS COVERED BY ONE OR MORE OF THE FOLLOWING PATENTS:

US 9,404,278; US 9,051,748; US 8,671,624; US 8,015,754; US 7,762,025; 7,823,338; CA 2,587,968; CA 2,682,764; EP 1812666; DZ 5173; EG 25627; NG RPNG/C/C2007/737; EP 2137356

CUSTOMER

MSSI STANDARDS

DRAWING NUMBER M1XX

DRAWN DATE	
PHOLBROOK	2/21/2023
REVIEW	DATE
JCALDWELL	3/8/2023
APPROVED	DATE
NMCCARTY	3/15/2023

REVISIONS

	REV	DESCRIPTION	DRAWN	DATE
	0	MANUFACTURI	PDH	2/21/2
		NG RELEASE	РИП	3
	1	MANUFACTURI	PDH	7/3/23
		NG RELEASE	РОП	113123
	2	MANUFACTURI	PDH	8/22/2
		NG RELEASE	РИП	3

ELECTRICAL PLAN

SHEET NUMBER
M1XX-E020

LIGHT, LED, FLOOD, PHOTOCELL, MOTION SENSOR -CIRCUIT 7 **NON-SECURE SIDE** LIGHT, LED, OVERHEAD, 4'-0" CIRCUIT 5 -TURNSTILE, SINGLE, ALVARADO CIRCUIT 2 __LIGHT, LED, OVERHEAD, 4'-0" CIRCUIT 5 RECEPTACLE, DUPLEX, GCFI, 120V -CIRCUIT 9 125A, 120/240V 1P, 100A MCB, NEMA 3, SURFACE MOUNT, 16 SPACES -SWITCH, SINGLE-POLE — CIRCUIT 5 **SECURE SIDE** LIGHT, LED, FLOOD, PHOTOCELL, MOTION SENSOR CIRCUIT 7 ELECTRICAL PLAN
SCALE: 3/4" = 1'-0"